


FRONT ELEVATION

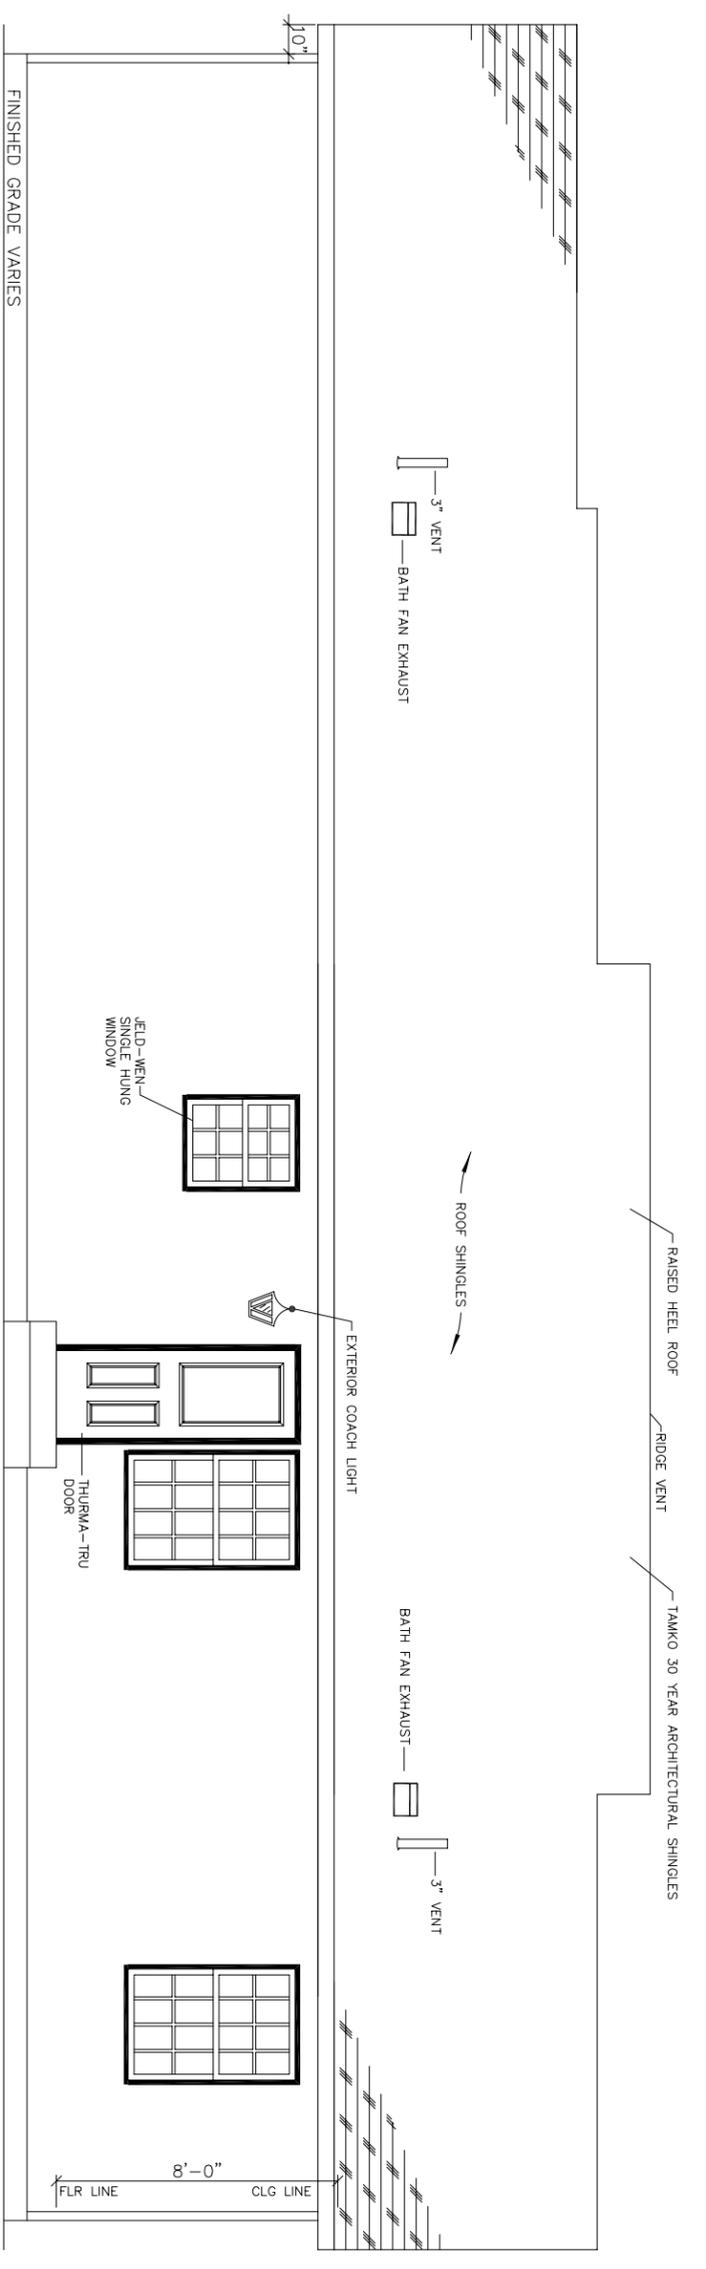

REAR ELEVATION

ATTIC VENTILATION SCHEDULE

MODULE	ATTIC AREA (SQ FT)	VENTILATION REQUIRED AREA (SQ IN) (ALL MODULES)	VENTILATION PROVIDED AREA (SQ IN)	REMARKS
A & B	1482	711	1456	
TOTAL		711	1456	MEETS VENT REQUIREMENTS

NOTES:

- 1) GABLE LOUVERS (WHEN REQUIRED) MUST MEET OR EXCEED REQUIRED FREE AREA LISTED ABOVE
- 2) 50% TO 80% OF VENTILATION PROVIDED BY GABLE LOUVERS OR RIDGE VENTS. REMAINDER OF VENTILATION REQUIRED TO BE PROVIDED BY EAVE VENTS.
- 3) SOFFIT NET FREE AREA = 3.9 SQ IN./LIN. FOOT
- 4) RIDGE VENT NET FREE AREA = 12.5 SQ IN./LIN. FOOT
- 5) VENTILATION REQUIRED BASED ON 1/500 OF TOTAL ATTIC AREA
- 6) OFF-PEAK UTILITY VENT NET FREE AREA = 9 SQ IN./LIN. FOOT

GENERAL ELEVATION NOTES:

- 1) ALL WINDOWS TO BE JELD-WEN SINGLE HUNG WINDOWS
- 2) ALL DOORS ARE THURMA-TRU
- 3) WHITE VENTED EAVE OVERHANGS/SOFFIT

LEGEND:

- \* = ON-SITE CONSTRUCTION AND MUST BE INSPECTED BY LOCAL

SHOP BY: \_\_\_\_\_  
DATE: \_\_\_\_\_

BUILDER: \_\_\_\_\_  
RETAIL: \_\_\_\_\_  
SALES PERSON: \_\_\_\_\_ STATE: \_\_\_\_\_

MODEL: \_\_\_\_\_  
RANCH

DRAWING: FRONT / REAR ELEVATIONS

SHEET: 4A

**SDD Inc.**  
GUANCHENG AREA, DONGGUAN  
GUANGDONG, CHINA, 523000  
TEL: 86-13724434142  
FAX: 86-769-22505796  
WWW.SUNFLOWERDRAFTING.COM

DWG #	DATE	REVISIONS	BY

DRAWN BY: \_\_\_\_\_ DATE: \_\_\_\_\_ SCALE: 3/16"=1'-0" TRACKING # \_\_\_\_\_

SERIAL # \_\_\_\_\_  
TRUSS TYPE: \_\_\_\_\_  
HEAT: \_\_\_\_\_  
CEILING HEIGHT: \_\_\_\_\_  
STAIR TYPE: \_\_\_\_\_